

KEYNOTES	
Key Value	Keynote Text

- GENERAL REFLECTED CEILING PLAN NOTES**
1. SEE MEP DRAWINGS FOR QUANTITIES OF LIGHTS, EQUIPMENT, DEVICES, AND DUCT TERMINALS.
 2. SEE A3 SERIES RCP DRAWINGS FOR LOCATIONS OF LIGHTS, EQUIPMENT, DEVICES, AND DUCT TERMINALS.
 3. SPRINKLER HEAD LOCATIONS ON RCP DRAWINGS ARE TO INDICATE DESIGN INTENT ONLY.
 4. CENTER ALL CEILING MOUNTED DEVICES AND SENSORS LOCATED IN CEILING GRID IN THE CENTER OF TILES, U.N.O.
 5. LOCATE ALL LIGHTS LOCATED IN CEILING GRID EITHER ON THE GRID OR CENTERED IN TILES. SEE ARCHITECTURAL RCP FOR EACH ROOM.

SMITHGROUP
architecture engineering interiors planning

SMITHGROUP, INC.
35 EAST WACKER
SUITE 2200
CHICAGO, IL 60601
T 312.641.0770
F 312.641.6728
www.smithgroup.com




JJR
landscape architecture
planning
urban design
civil engineering
environmental science

JJR, LLC
35 EAST WACKER DRIVE
SUITE 2200
CHICAGO, ILLINOIS 60601
312.641.0510 T
312.641.0668 F
www.jjr-us.com

A&E Affiliated Engineers
Affiliated Engineers, Inc.
5802 Research Park Boulevard
Madison, Wisconsin 53719
Tel 608.238.2616 Fax 608.238.2614

Thornton Tomasetti
Thornton Tomasetti, Inc.
330 N. Wabash Avenue, Suite 1500
Chicago IL 60611-7622
T 312.596.3000 F 312.596.3001

TERRA ENGINEERING LTD.
225 West Ohio Street, 4th Floor
Chicago, Illinois 60654
T: (312) 467-0123 F: (312) 467-0220

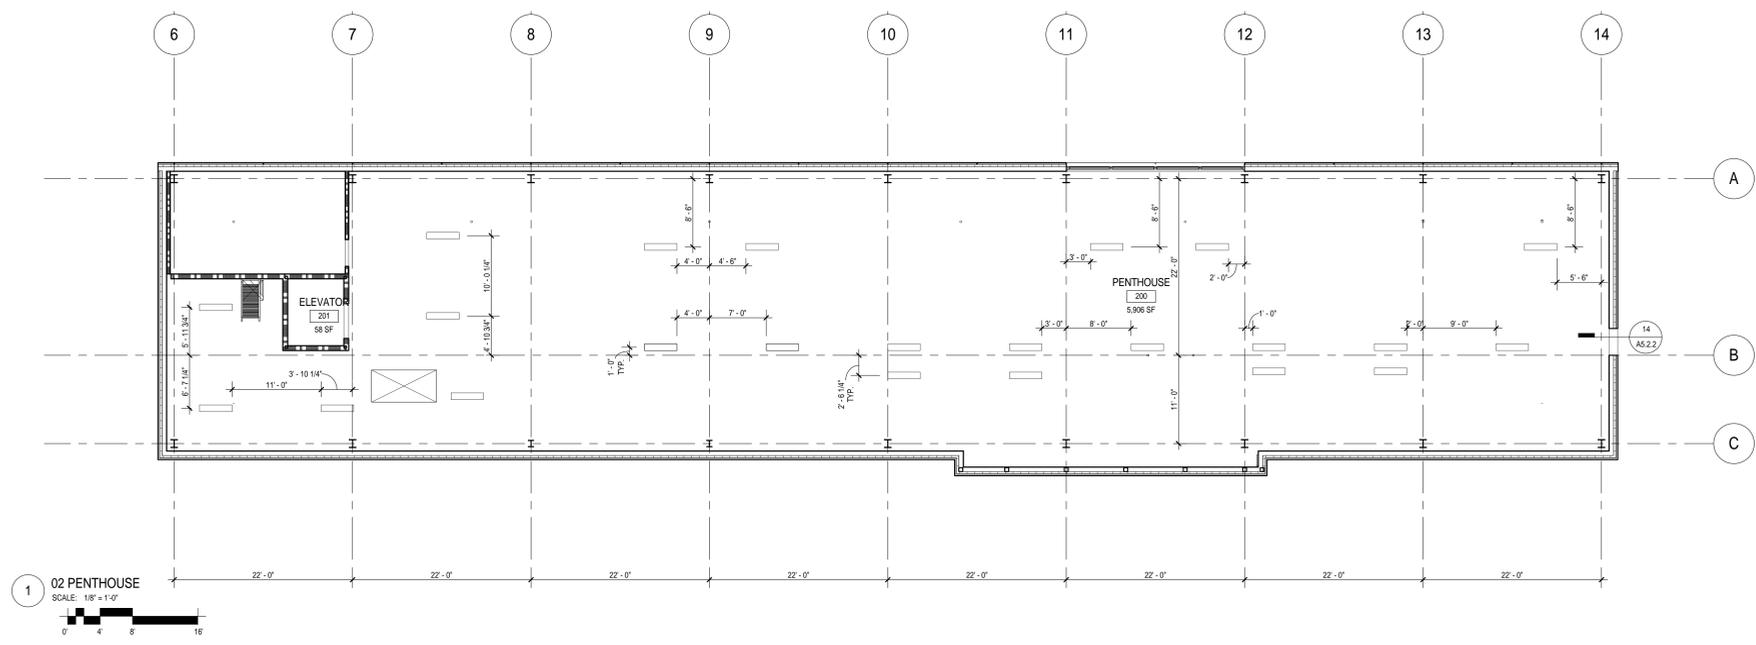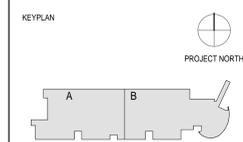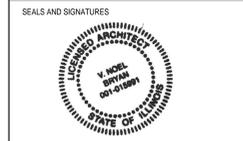

REV. NO.	DESCRIPTION	BY	APVD	DATE

ISSUED FOR CONSTRUCTION 07/23/12

Argonne
NATIONAL LABORATORY

FMS
Facilities Management Services

PROJECT TITLE ADVANCED PROTEIN CRYSTALLIZATION FACILITY, ARGONNE NATIONAL LABORATORY
PROJECT NO 22378.000

02 PENTHOUSE REFLECTED CEILING PLAN

DESIGNED	A/E CAD FILE	FACILITY NO(S)
TT	A3.2.0	
DRAWN	A/E DWG. NO.	
AR, BJ	A3.2.0	
CHECKED	CAD NO.	
LH		
PROJECT MANAGER	DWG STATE	
ANL - JESSE ADAMS	BND ORDER	
DATE - 05/06/11		
FACILITY DOCUMENT NUMBER		REV. NO.
J446-101-W-		A3.2.0