


SHEET NOTE:
 1. PIPING TO TERMINAL HEATING-COOLING DEVICES
 TO BE 3/4" UNLESS OTHERWISE NOTED

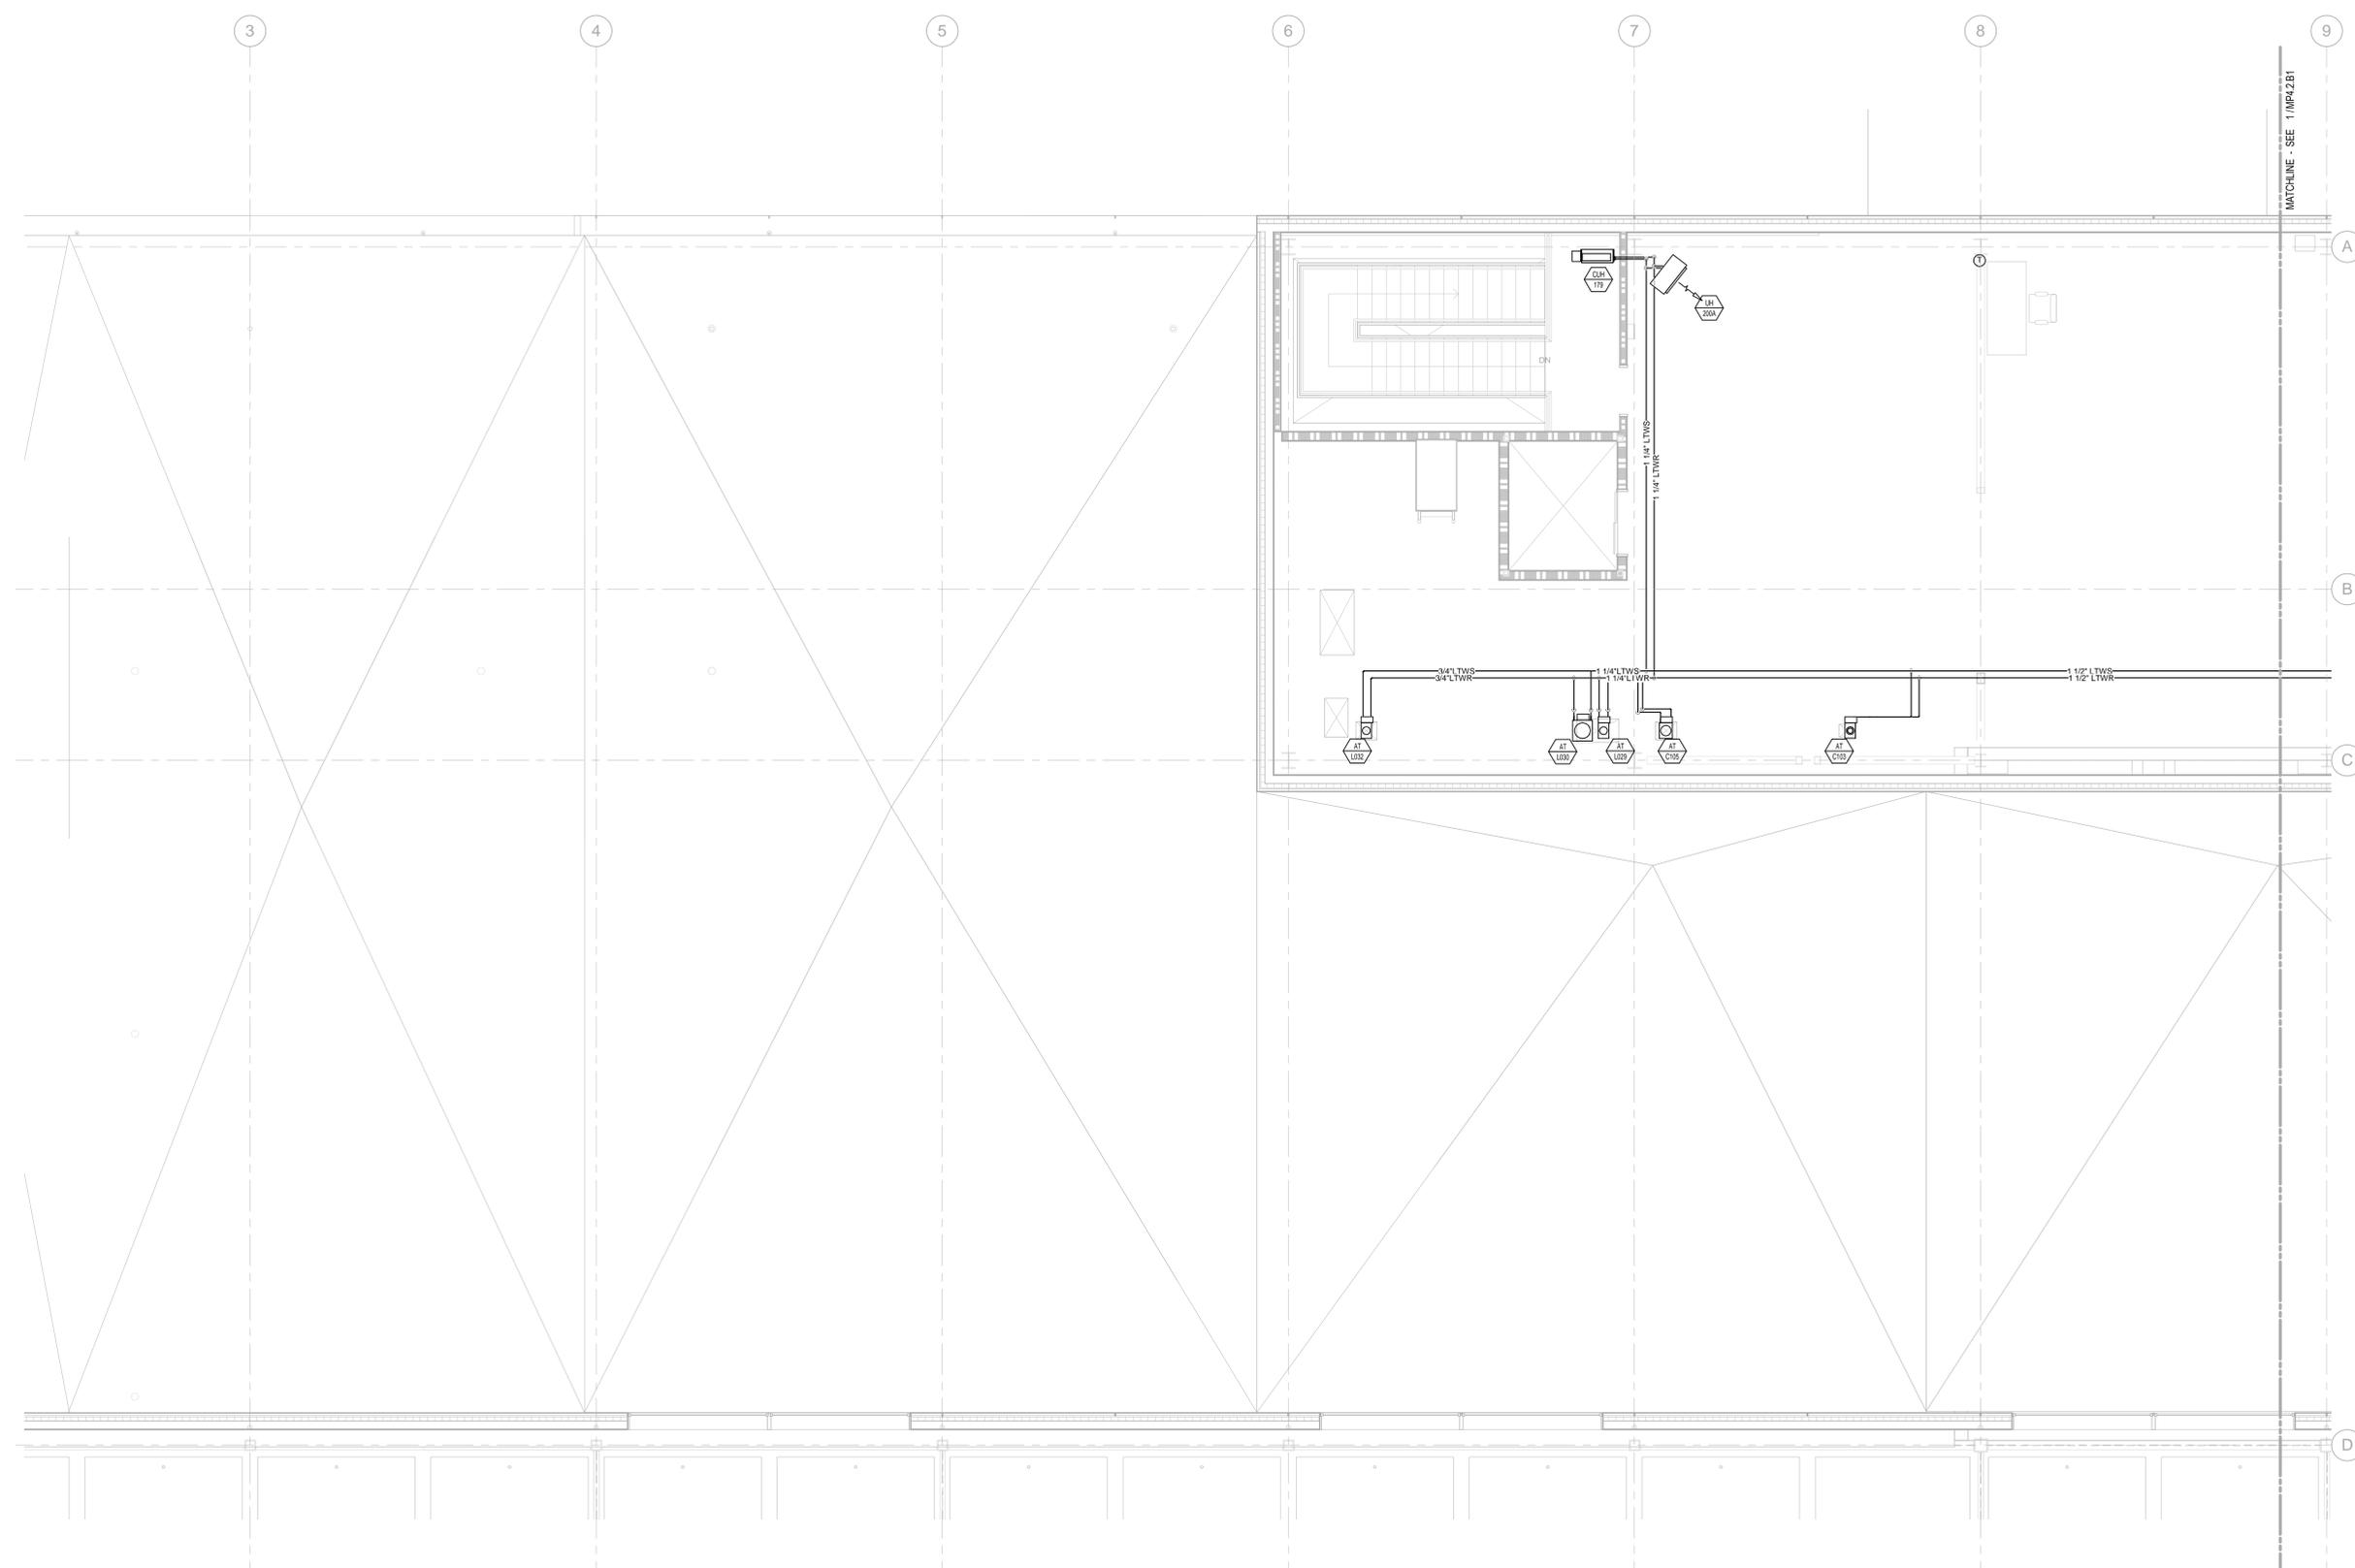

MATCHLINE - SEE 1 IMP4.2B1

SMITHGROUP
 architecture engineering interiors planning

SMITHGROUP, INC.
 35 EAST WACKER
 SUITE 2200
 CHICAGO, IL 60601
 T 312.641.0770
 F 312.641.6728
 www.smithgroup.com

JJR

JJR, LLC
 35 EAST WACKER DRIVE
 SUITE 2200
 CHICAGO, ILLINOIS 60601
 312.641.0510 T
 312.641.0668 F
 www.jjr-us.com

A&E Affiliated Engineers

Affiliated Engineers, Inc.
 5802 Research Park Boulevard
 Madison, Wisconsin 53719
 Tel 608.238.2616 Fax 608.238.2614

Thornton Tomasetti

Thornton Tomasetti, Inc.
 330 N. Wabash Avenue, Suite 1500
 Chicago IL 60611-7622
 T 312.596.2000 F 312.596.2001

 
TERRA ENGINEERING LTD.

225 West Ohio Street, 4th Floor
 Chicago, Illinois 60654
 T 312.467.0123 F 312.467.0220

SEALS AND SIGNATURES



KEYPLAN



ISSUED FOR CONSTRUCTION 07/02/12

REV. NO.	DESCRIPTION	BY	APVD	DATE



FMS
 Facilities Management Services

PROJECT TITLE ADVANCED PROTEIN
 CRYSTALLIZATION FACILITY,
 ARGONNE NATIONAL LABORATORY
 PROJECT NO 08541-00

**ENLARGED PENTHOUSE
 MECHANICAL PIPING
 PLAN A1**

DESIGNED	SPF	A/E CAD FILE	FACILITY
		MP4.2.A1	NOIS
DRAWN	LW	A/E DWG. NO.	
		MP4.2.A1	
CHECKED	SPF	CAD NO.	
PROJECT MANAGER	ANL - JESSE ADAMS	DWG STATE	
		DATE - 04/26/11	BND ORDER
		FACILITY DOCUMENT NUMBER	REV. NO.
		J446-101-W-	MP4.2.A1

1 ENLARGED PENTHOUSE MECHANICAL PIPING PLAN A1
 1/4" = 1'-0"